
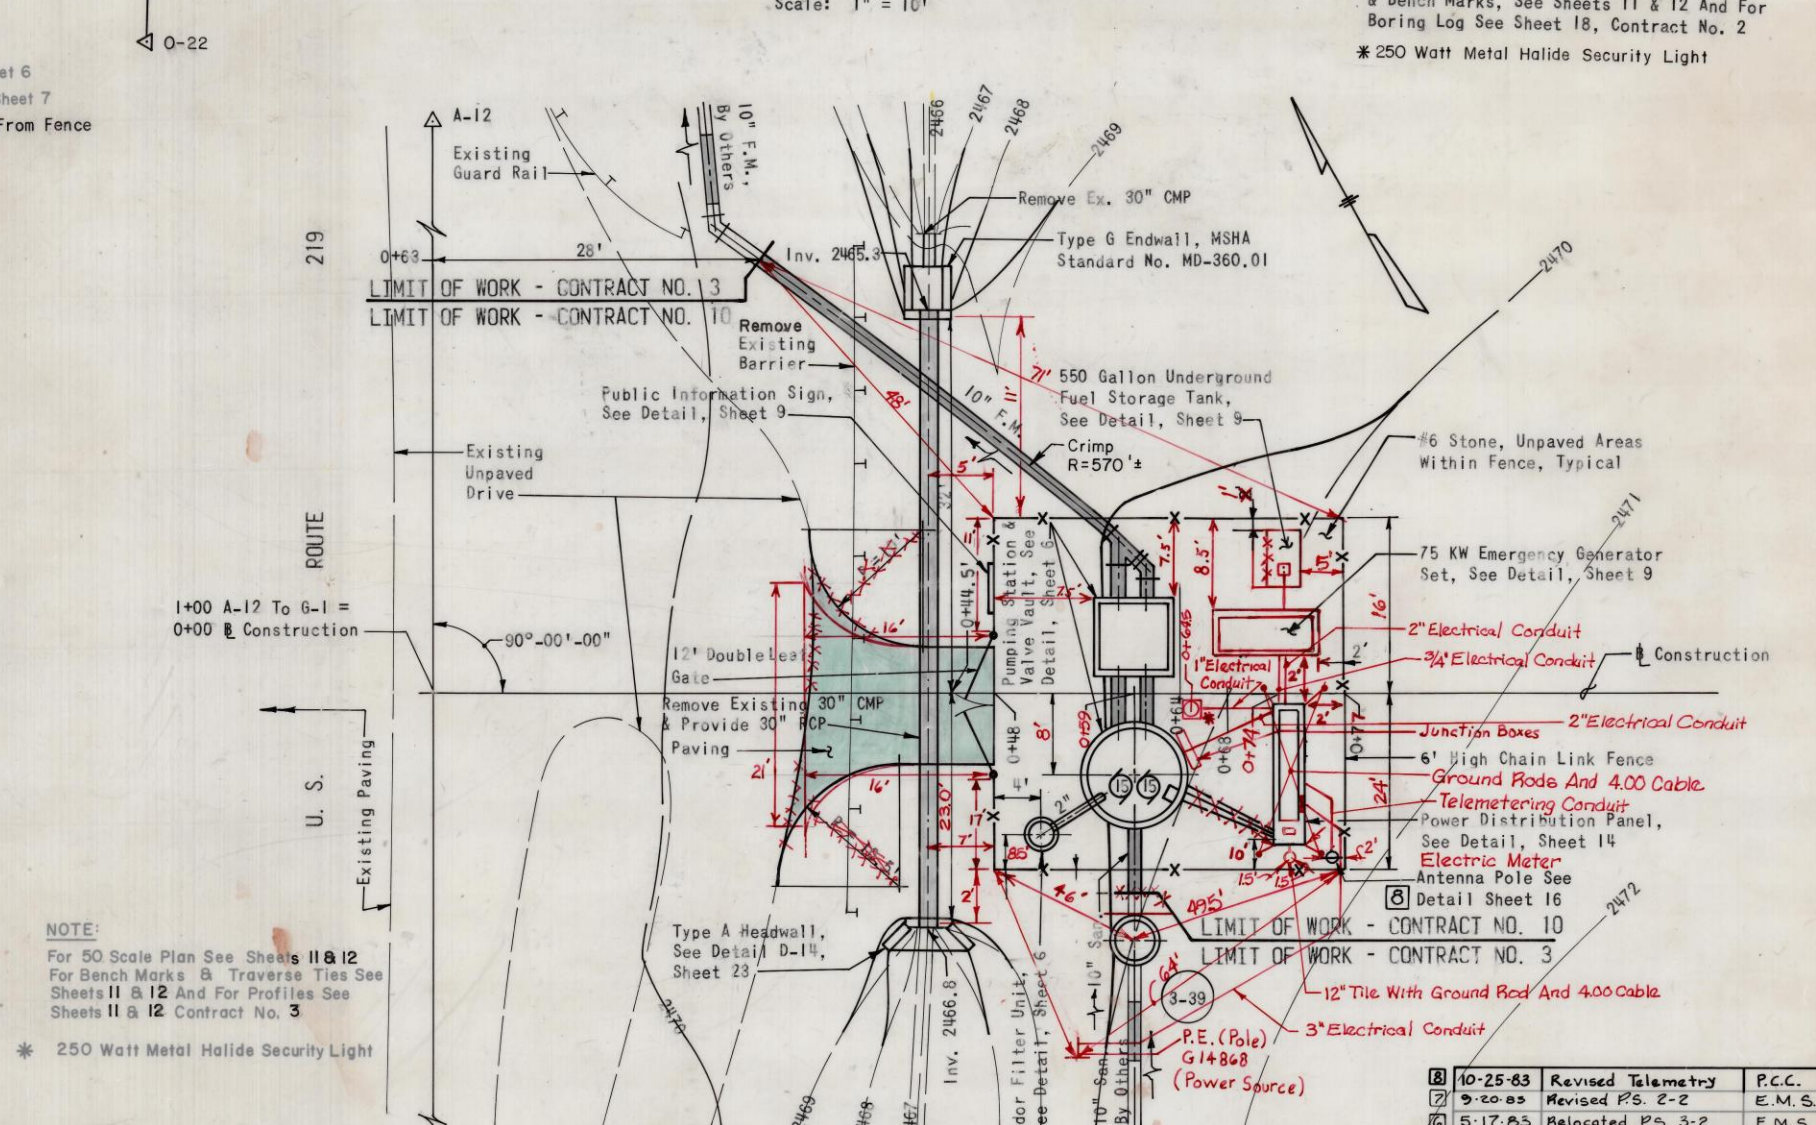
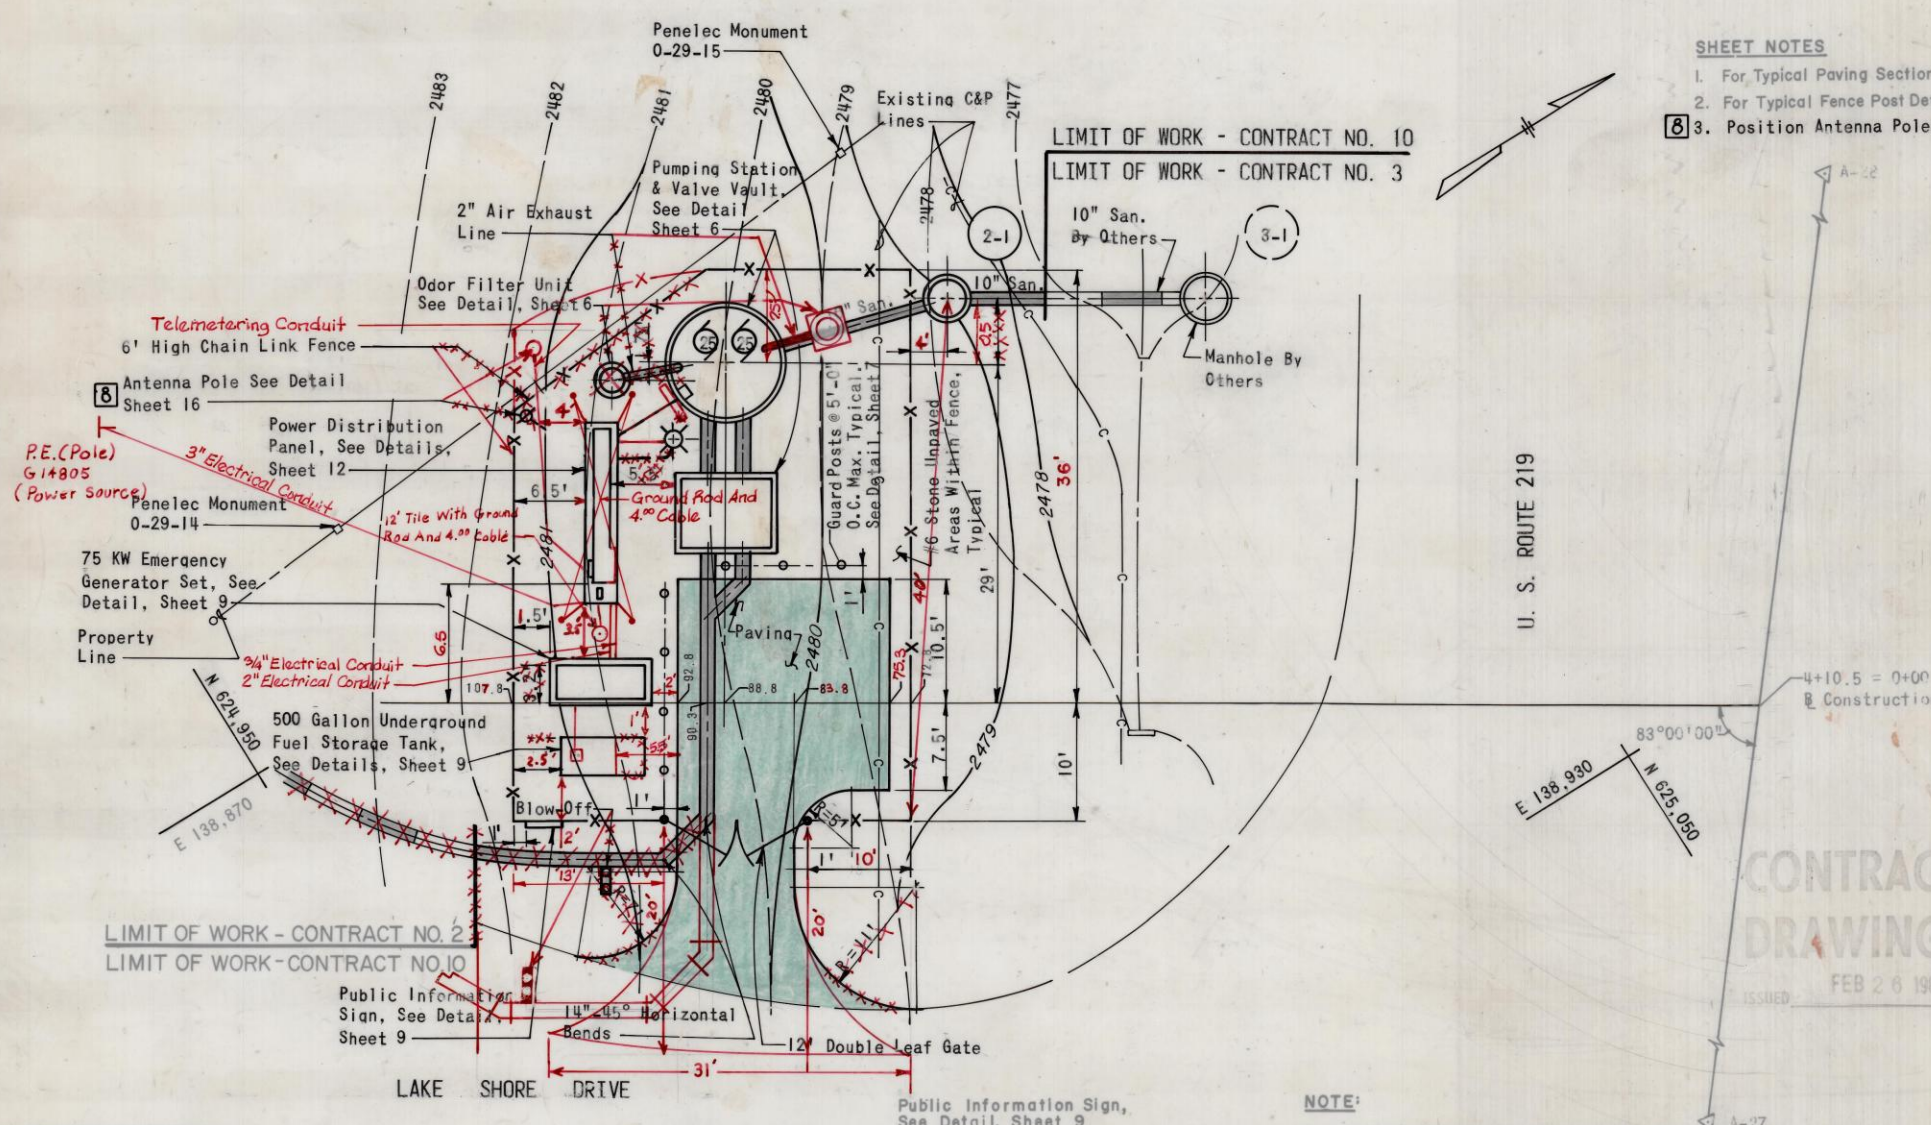
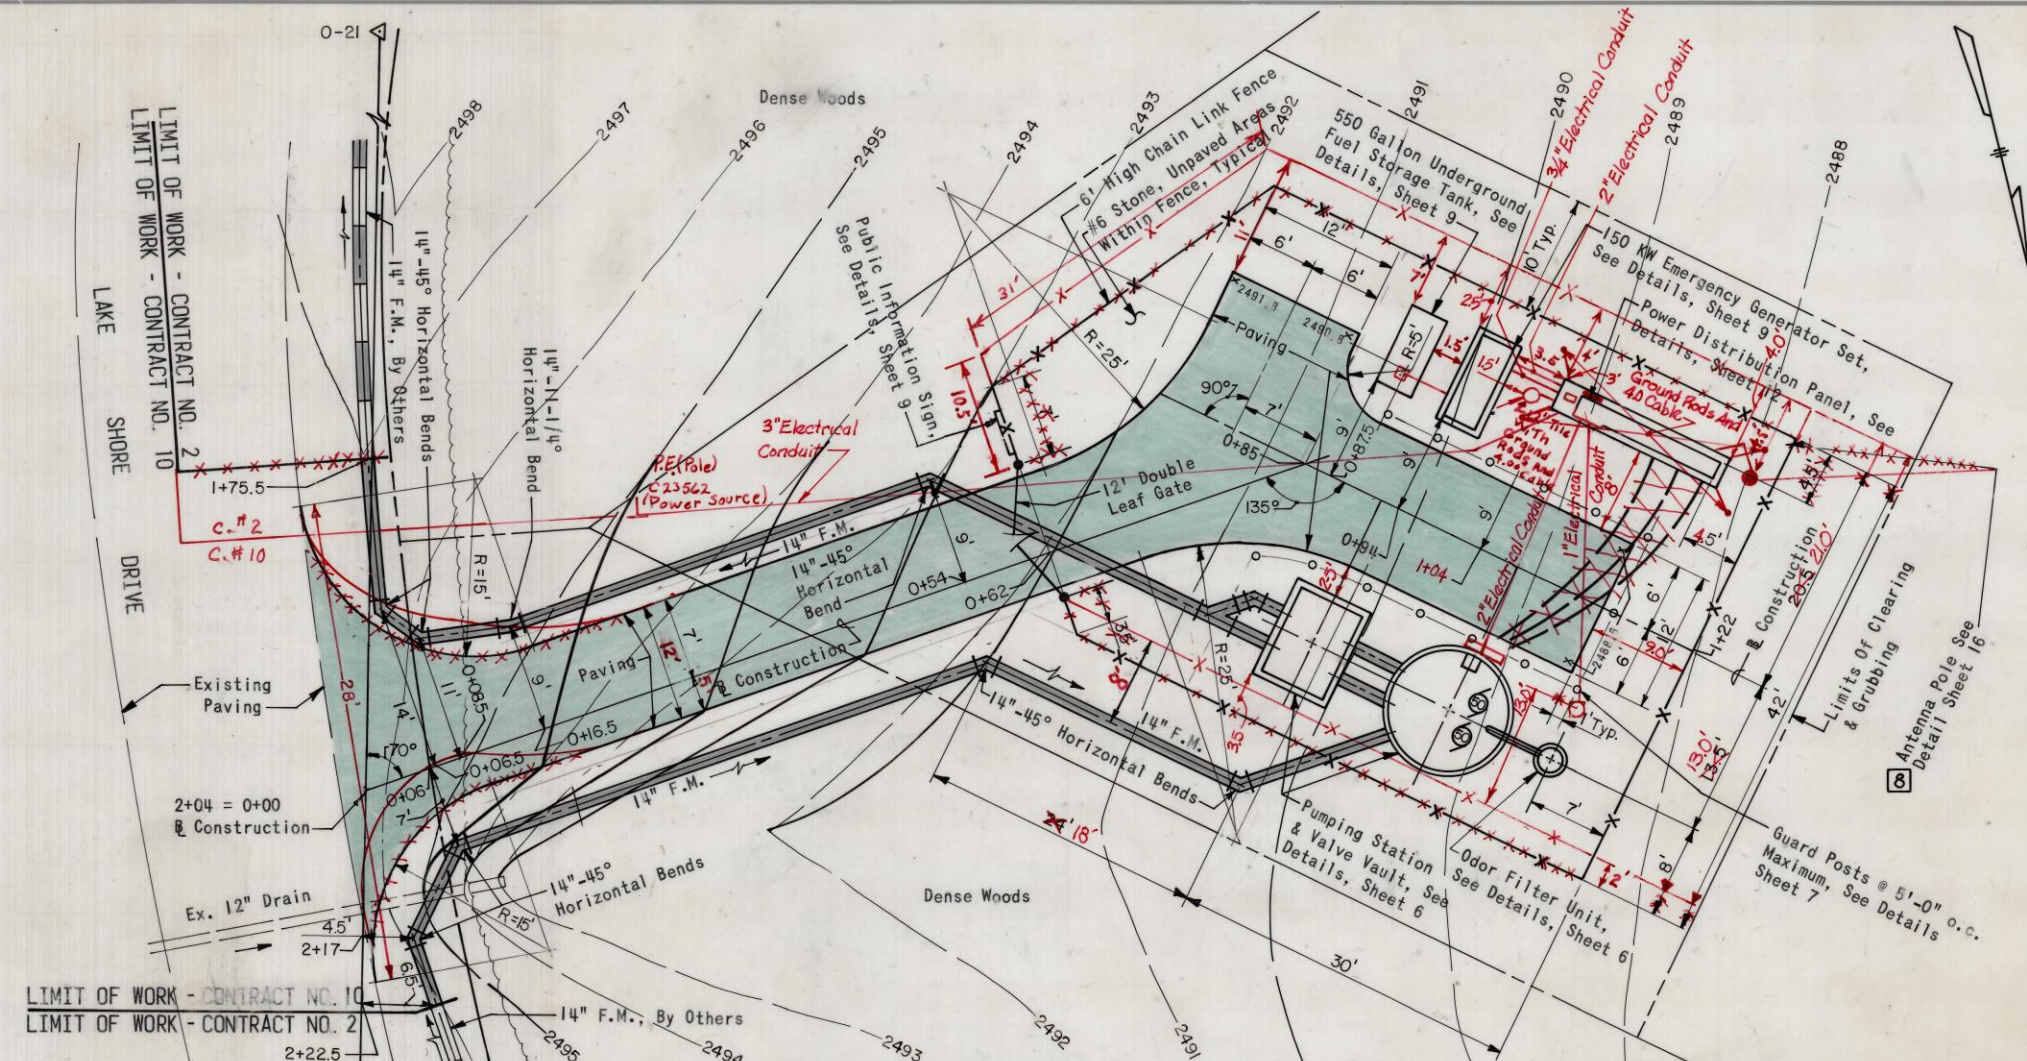


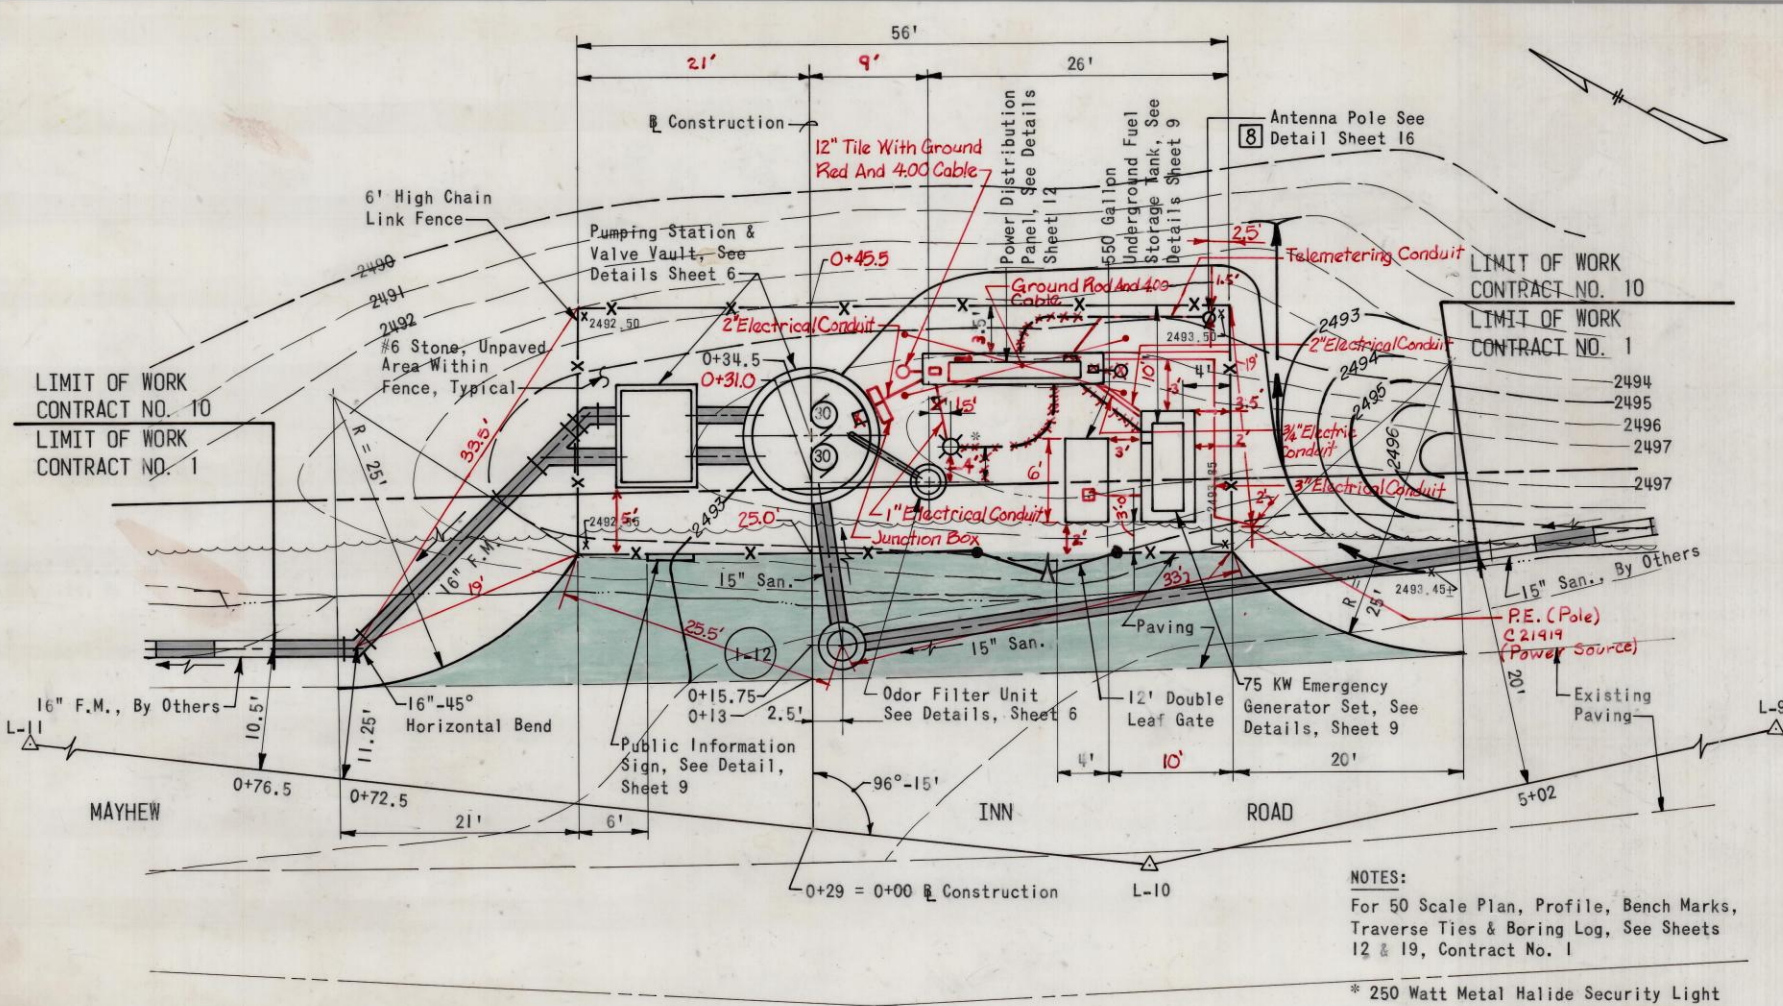

SHEET NOTES
1. For Typical Paving Section, See Sheet 6
2. For Typical Fence Post Detail, See Sheet 7
3. Position Antenna Poles 4'-0" From Fence

CONTRACT DRAWINGS
ISSUED FEB 26 1992

10-25-83	Revised Telemetry	P.C.C.
9-20-82	Revised P.S. 2-2	E.M.S.
5-17-83	Allocated P.S. 3-2	E.M.S.
5-2-83	Revised Alignment	E.M.S.
4-27-83	Revised Telemetry	P.C.C.
3/29/83	Added Head Trans. Control Cable	
5-12-82	Revised Stationing	E.M.S.
DATE	REVISED BY	

RUMMEL, KLEPPER & KAHL
CONSULTING ENGINEERS
BALTIMORE, MARYLAND

ENGINEER
REG. NO. 3381
DESIGNED BY
DRAWN BY
DATE
CHECKED BY

PROJECT C-240565-03
DEEP CREEK LAKE SANITARY
DISTRICT SEWERAGE FACILITIES

CONTRACT NO. 10
PUMPING STATIONS

SITE PLANS
PUMPING STATIONS 1-1, 2-2 & 3-2

DRAWING COMPLETED
SCALE AS SHOWN
POSITION SHEET
SHEET NO. 3 OF 25